


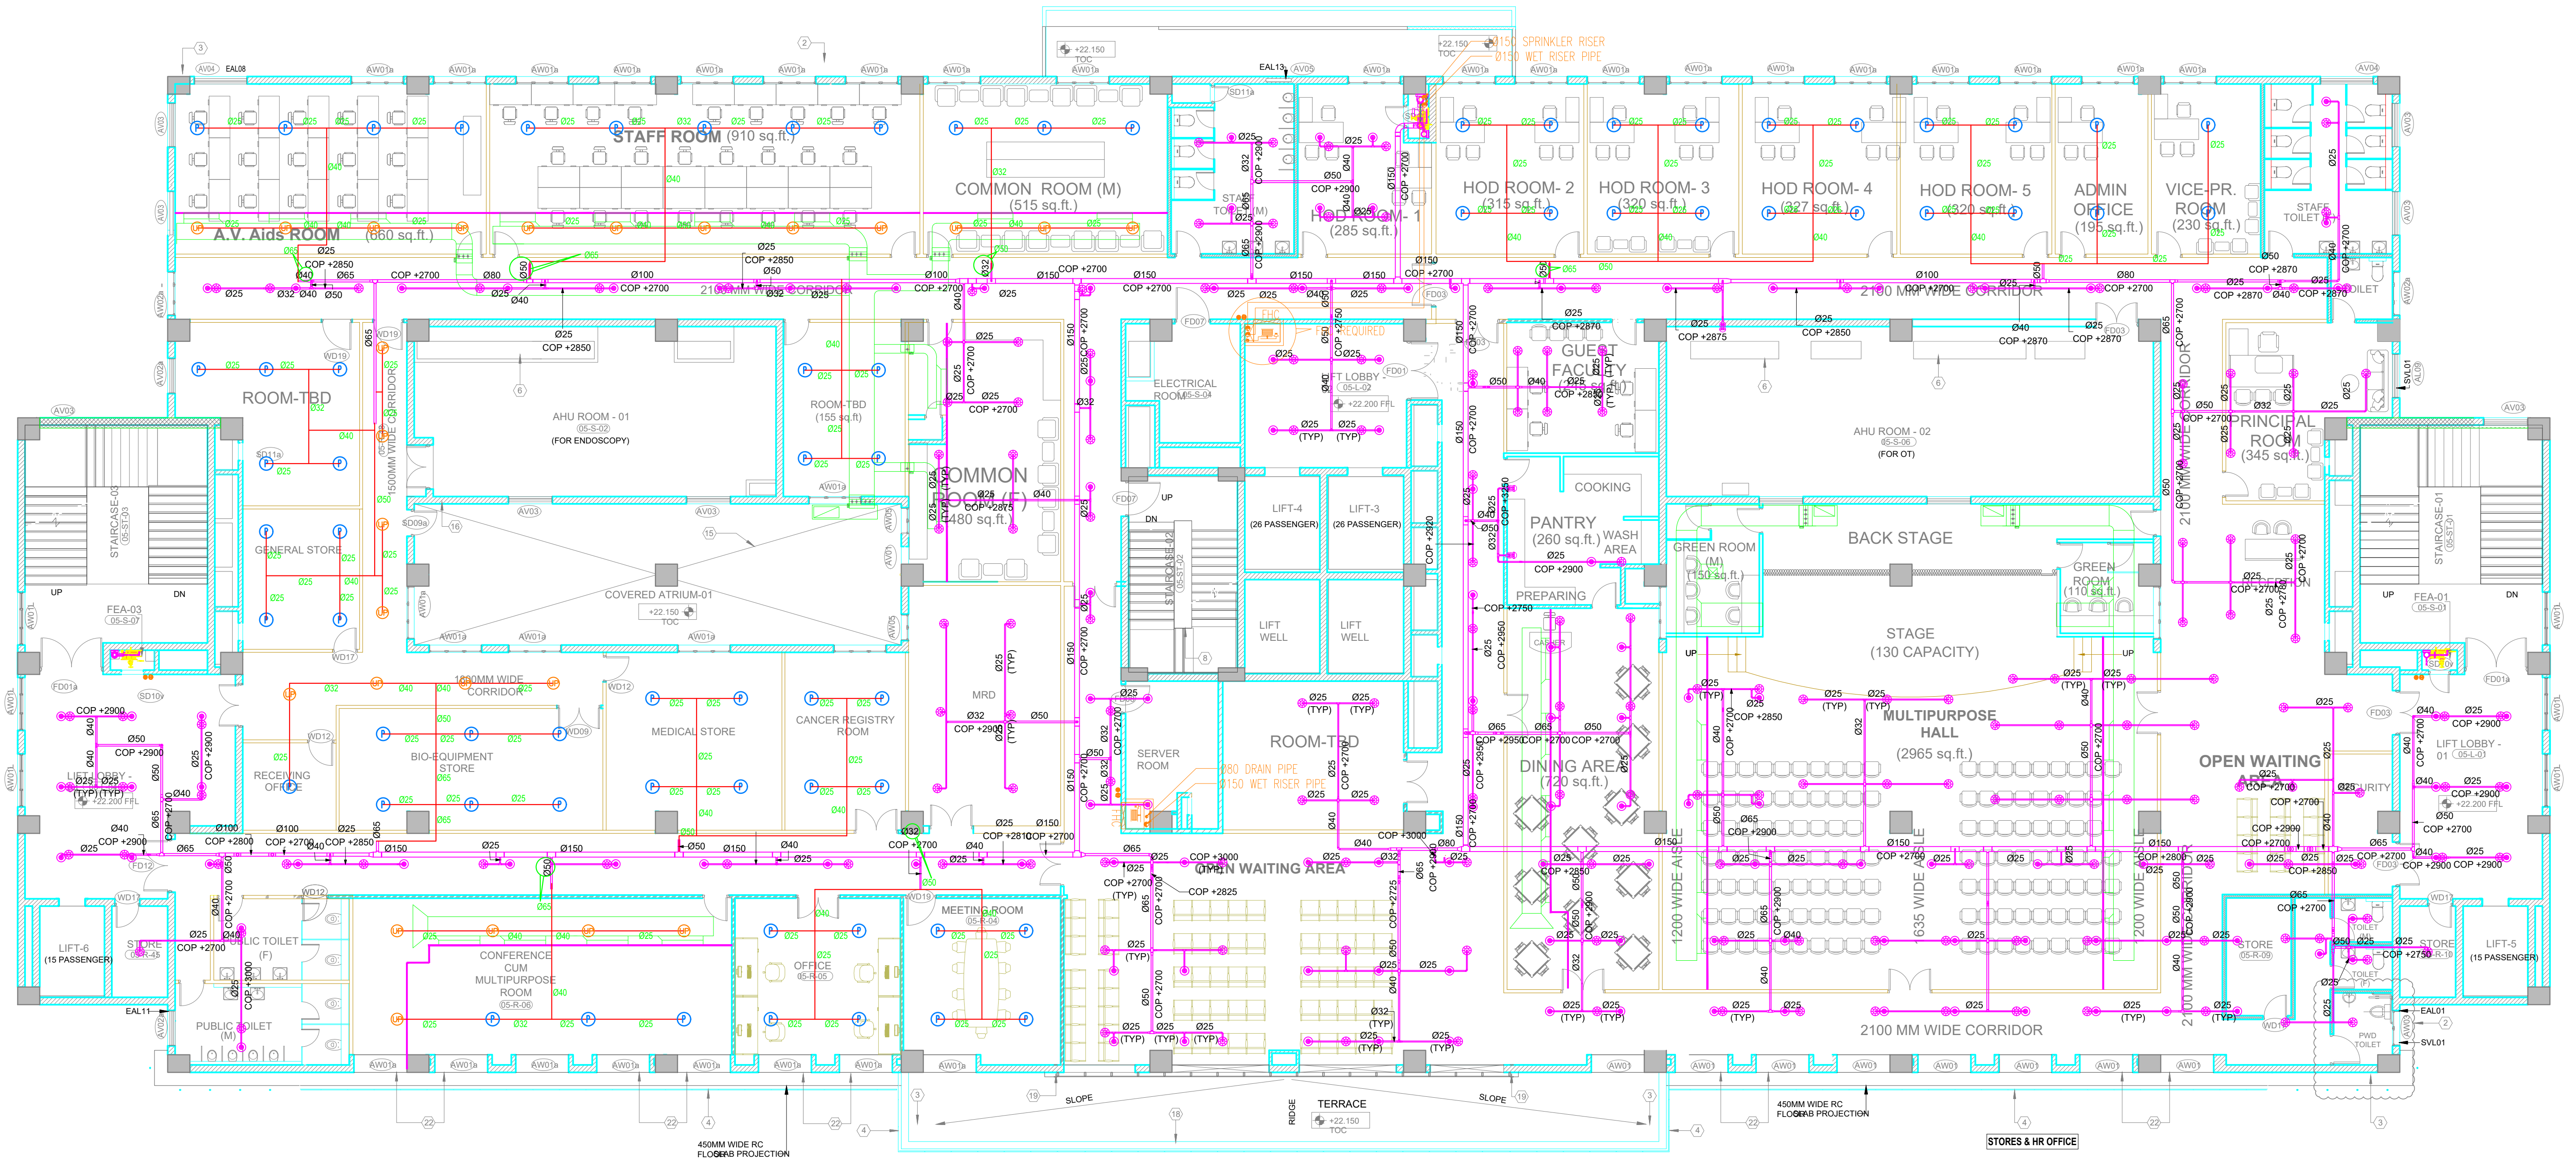

SPRINKLER LAYOUT TO BE DISCUSSED

# PROPOSED NURSING COLLEGE - FIFTH FLOOR

LEGEND: –

|     |                                              |
|-----|----------------------------------------------|
| FHC | FIRE HOSE CABINET                            |
| —   | SPRINKLER PIPE                               |
| ⊙   | 4.5 Kg CO2 FIRE EXTINGUISHER                 |
| ●   | 6 Kg ABC TYPE FIRE EXTINGUISHER              |
| Ⓟ   | PENDENT SPRINKLER (QUICK RESPONSE)           |
| Ⓢ   | UPRIGHT & PENDENT SPRINKLER (QUICK RESPONSE) |
| FHC | FIRE HOSE CABINET                            |

PROJECT NAME  
PROPOSED OF NURSING COLLEGE AT 5TH AND 6TH FLOOR OF DIPHU CANCER CENTRE, DIPHU

CLIENT  
ASSAM CANCER CARE FOUNDATION

DRAWING TITLE  
FIFTH FLOOR PLAN  
PROPOSED NURSING COLLEGE

AREA

DWG NO. ASSM/DCC/DIPHU/FIFTH FLOOR/FIRE FIGHTING 101

DATE

SCALE

DWN BY LVE

REVISION DATA

NOTE:

1. Do not scale the drawing, follow written dimension only.
2. All dimensions in mm. and levels in meters.
3. This dwg should be read along with relevant structural dwg.
4. Toilet, Pantry, Kitchen level shall be 12mm below the FFL.

CONSULTANT

LUIT VALLEY ENGINEERING PVT. LTD.  
PALTAN BAZAR, GUWAHATI 781008(INDIA)