


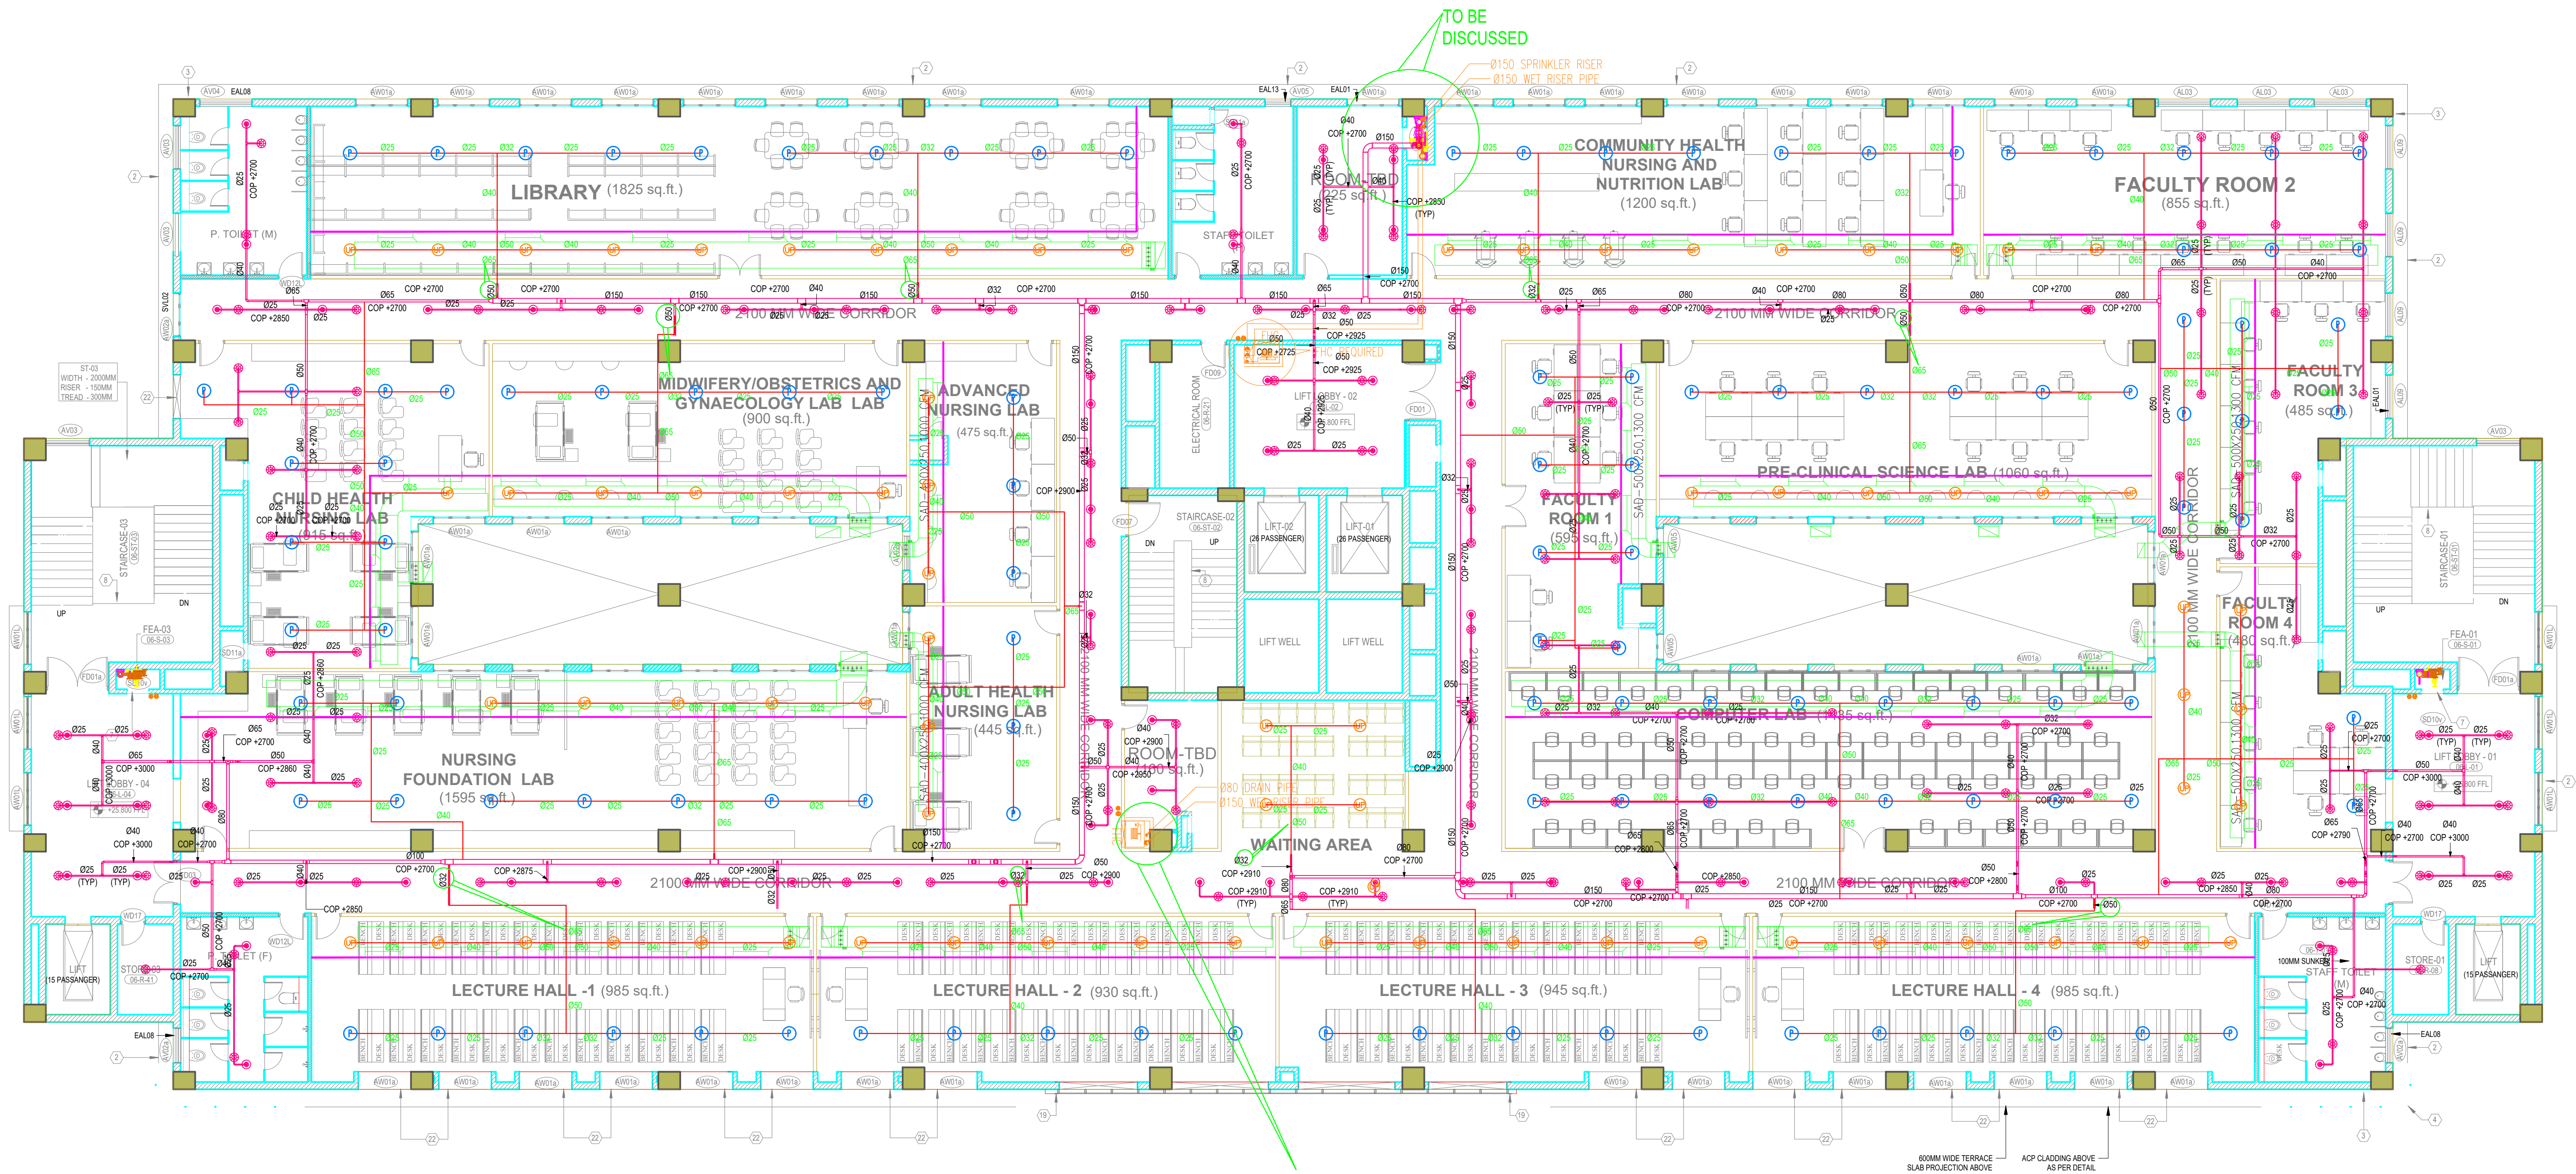

PROPOSED NURSING COLLEGE - SIXTH FLOOR

LEGEND: –

FHC	FIRE HOSE CABINET
—	SPRINKLER PIPE
⊙	4.5 Kg CO2 FIRE EXTINGUISHER
●	6 Kg ABC TYPE FIRE EXTINGUISHER
Ⓟ	PENDENT SPRINKLER (QUICK RESPONSE)
Ⓢ	UPRIGHT & PENDENT SPRINKLER (QUICK RESPONSE)
FHC	FIRE HOSE CABINET

PROJECT NAME
PROPOSED OF NURSING COLLEGE AT 5TH AND 6TH FLOOR OF DIPHU CANCER CENTRE, DIPHU

CLIENT
ASSAM CANCER CARE FOUNDATION

DRAWING TITLE
SIXTH FLOOR PLAN
PROPOSED NURSING COLLEGE

AREA

DWG NO. ASSM/DCC/DIPHU/SIXTH FLOOR/FIRE FIGHTING 102

DATE

SCALE

DWN BY LVE

REVISION DATA

NOTE:

1. Do not scale the drawing, follow written dimension only.
2. All dimensions in mm. and levels in meters.
3. This dwg should be read along with relevant structural dwg.
4. Toilet, Pantry, Kitchen level shall be 12mm below the FFL.

CONSULTANT

LUIT VALLEY ENGINEERING PVT. LTD.
PALTAN BAZAR, GUWAHATI 781008(INDIA)