


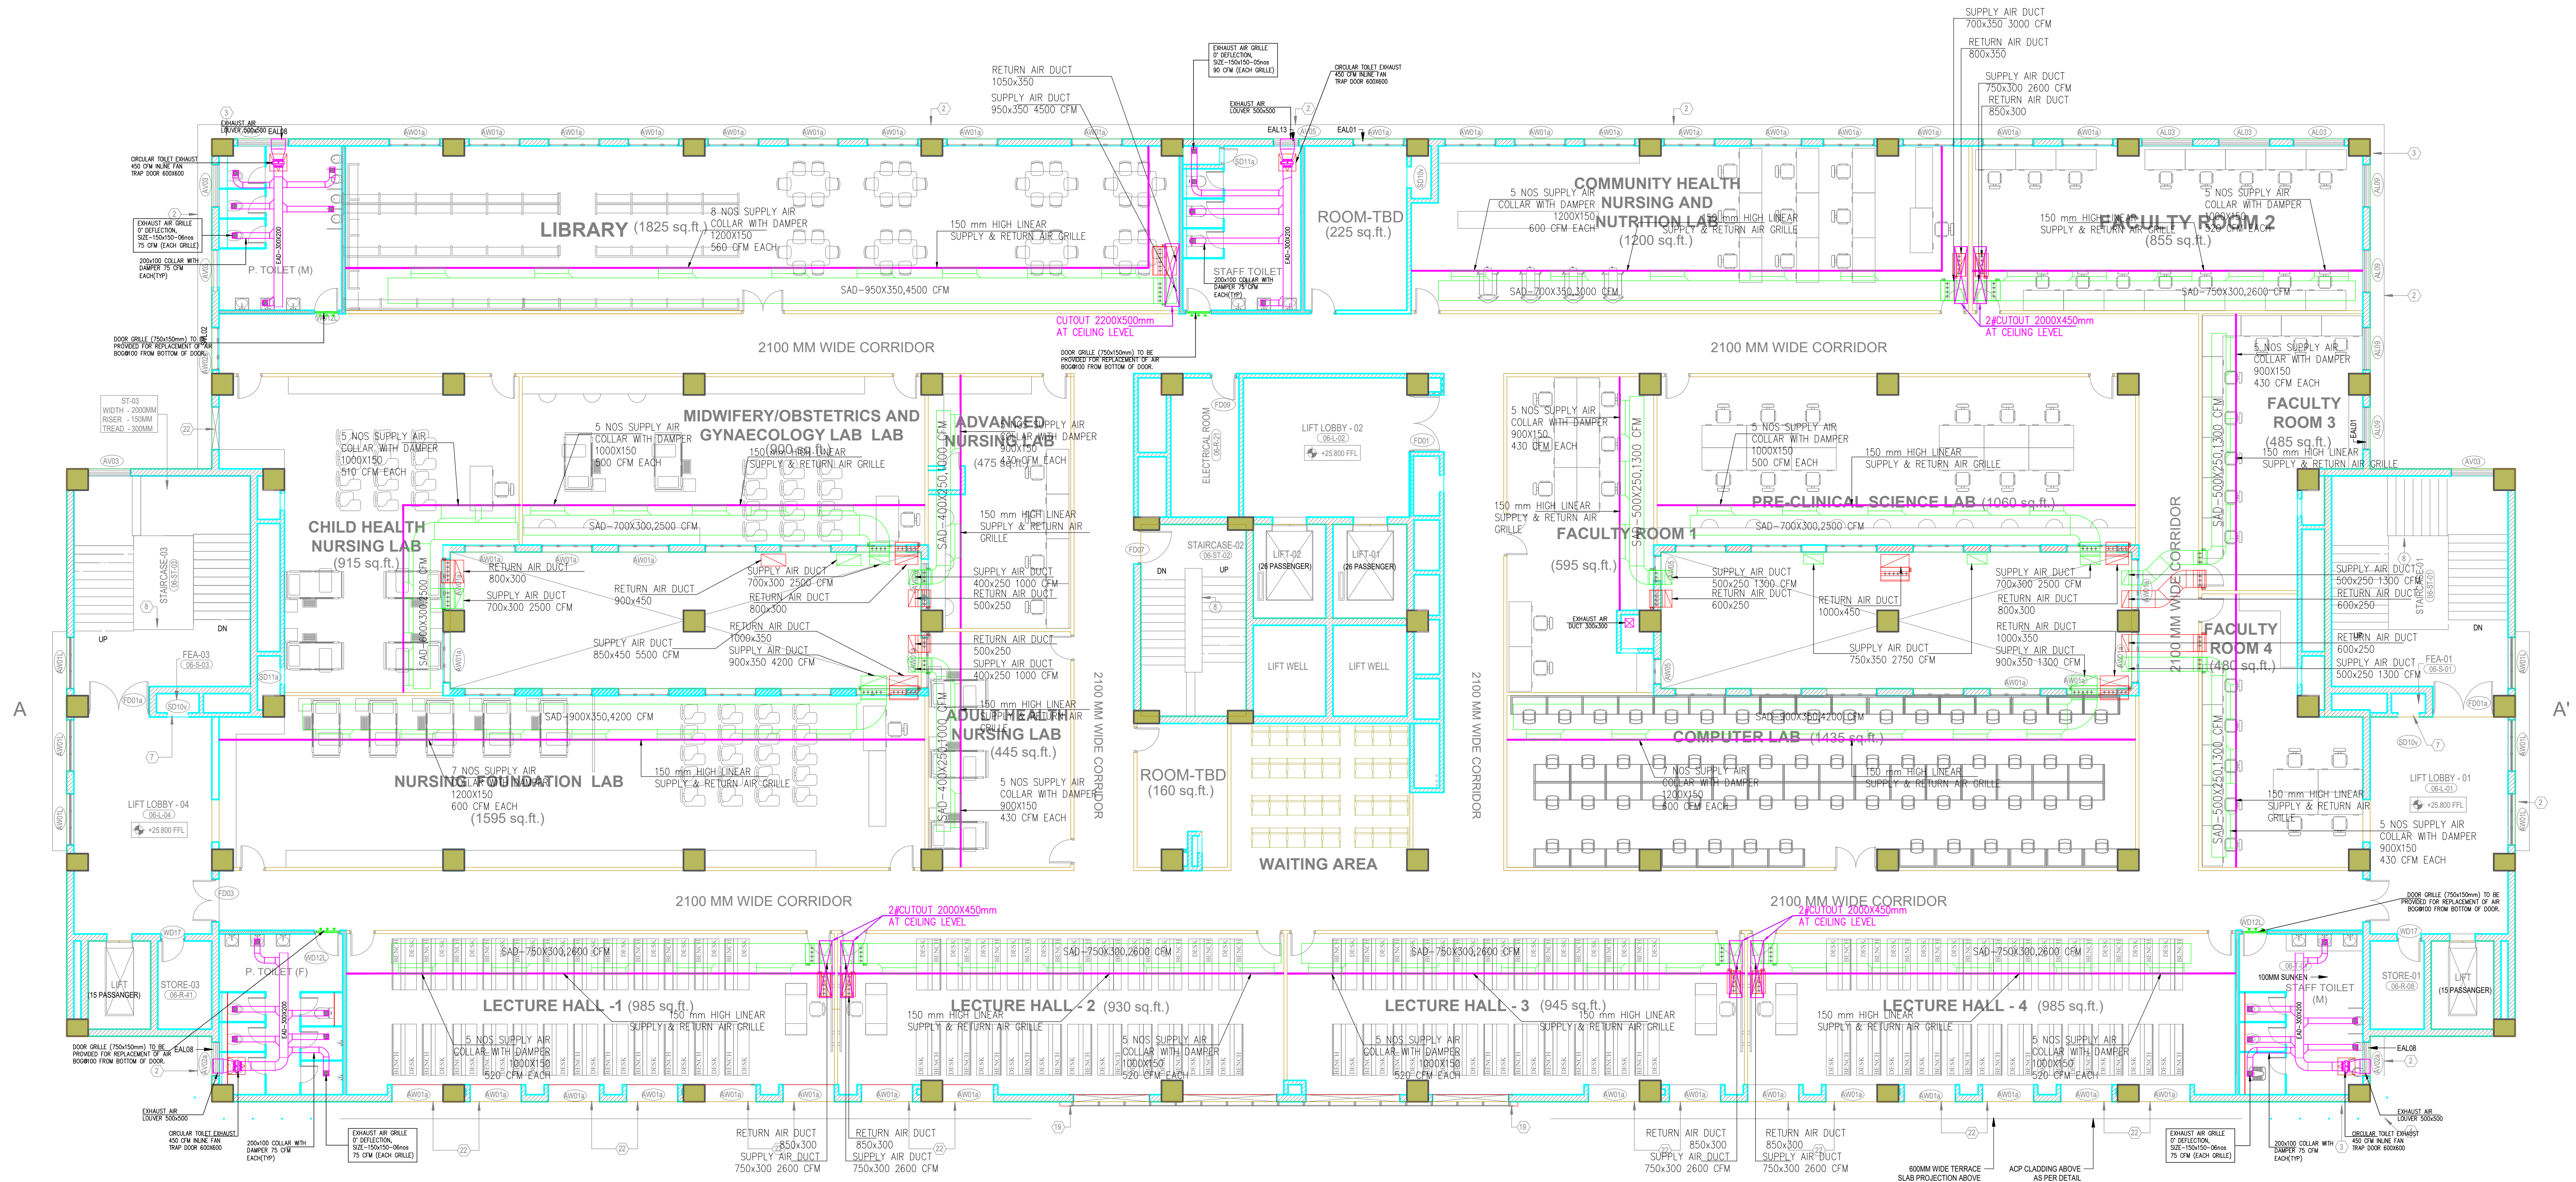

PROPOSED NURSING COLLEGE - SIXTH FLOOR

NOTE-
MINIMUM 25mm UNDER DOOR CUT TO BE PROVIDED IN WC, JANITOR & SHOWER.

EQUIPMENTS SCHEDULE:-

S. No.	SERVED AREA	DESCRIPTION	TAG No.	Selected units Selected unit	Unit Size-HxWxD in mm	PIPE DIA
1	6TH FLOOR	OUTDOOR UNIT	ODU-6A	32 HP	(1657X1240X765)+(1657X1240X765)	GAS-34.9ø LIQ-19.1ø
2	6TH FLOOR	OUTDOOR UNIT	ODU-6B	50 HP	(1657X1240X765)+(1657X1240X765)+(1657X1240X765)	GAS-41.3ø LIQ-19.1ø
3	6TH FLOOR	OUTDOOR UNIT	ODU-6C	34 HP	(1657X1240X765)+(1657X1240X765)	GAS-34.9ø LIQ-19.1ø
4	6TH FLOOR	OUTDOOR UNIT	ODU-6D	20 HP	(1657X1240X765)	GAS-28.6ø LIQ-15.9ø
5	6TH FLOOR	OUTDOOR UNIT	ODU-6E	32 HP	(1657X1240X765)+(1657X1240X765)	GAS-34.9ø LIQ-19.1ø
6	6TH FLOOR	OUTDOOR UNIT	ODU-6F	38 HP	(1657X1240X765)+(1657X1240X765)	GAS-41.3ø LIQ-19.1ø
7	5TH FLOOR	OUTDOOR UNIT	ODU-5A	20 HP	(1657X1240X765)	GAS-28.6ø LIQ-15.9ø
8	5TH FLOOR	OUTDOOR UNIT	ODU-5B	14 HP	(1657X1240X765)	GAS-28.6ø LIQ-12.7ø
9	5TH FLOOR	OUTDOOR UNIT	ODU-5C	12 HP	(1657X930X765)	GAS-22.2ø LIQ-9.5ø
10	5TH FLOOR	OUTDOOR UNIT	ODU-5D	26 HP	(1657X930X765)+(1657X930X765)	GAS-34.9ø LIQ-19.1ø
11	5TH FLOOR	OUTDOOR UNIT	ODU-5E	24 HP	(1657X930X765)+(1657X930X765)	GAS-34.9ø LIQ-15.9ø
12	5TH FLOOR	OUTDOOR UNIT	ODU-5F	30 HP	(1657X930X765)+(1657X1240X765)	GAS-34.9ø LIQ-19.1ø

PROJECT NAME
PROPOSED OF NURSING COLLEGE AT 5TH AND 6TH FLOOR OF
DIPHU CANCER CENTRE, DIPHU

CLIENT
ASSAM CANCER CARE FOUNDATION

DRAWING TITLE
SIXTH FLOOR PLAN
PROPOSED NURSING COLLEGE

AREA

DWG NO. ASSM/DCC/DIPHU/SIXTH
FLOOR/HVAC 102

DATE

SCALE

DWN BY LVE

REVISION DATA

NOTE:

1. Do not scale the drawing, follow written dimension only.
2. All dimensions in mm. and levels in meters.
3. This dwg should be read along with relevant structural dwg.
4. Toilet, Pantry, Kitchen level shall be 12mm below the FFL.

CONSULTANT

LUIT VALLEY ENGINEERING PVT. LTD.
PALTAN BAZAR, GUWAHATI 781008(INDIA)