


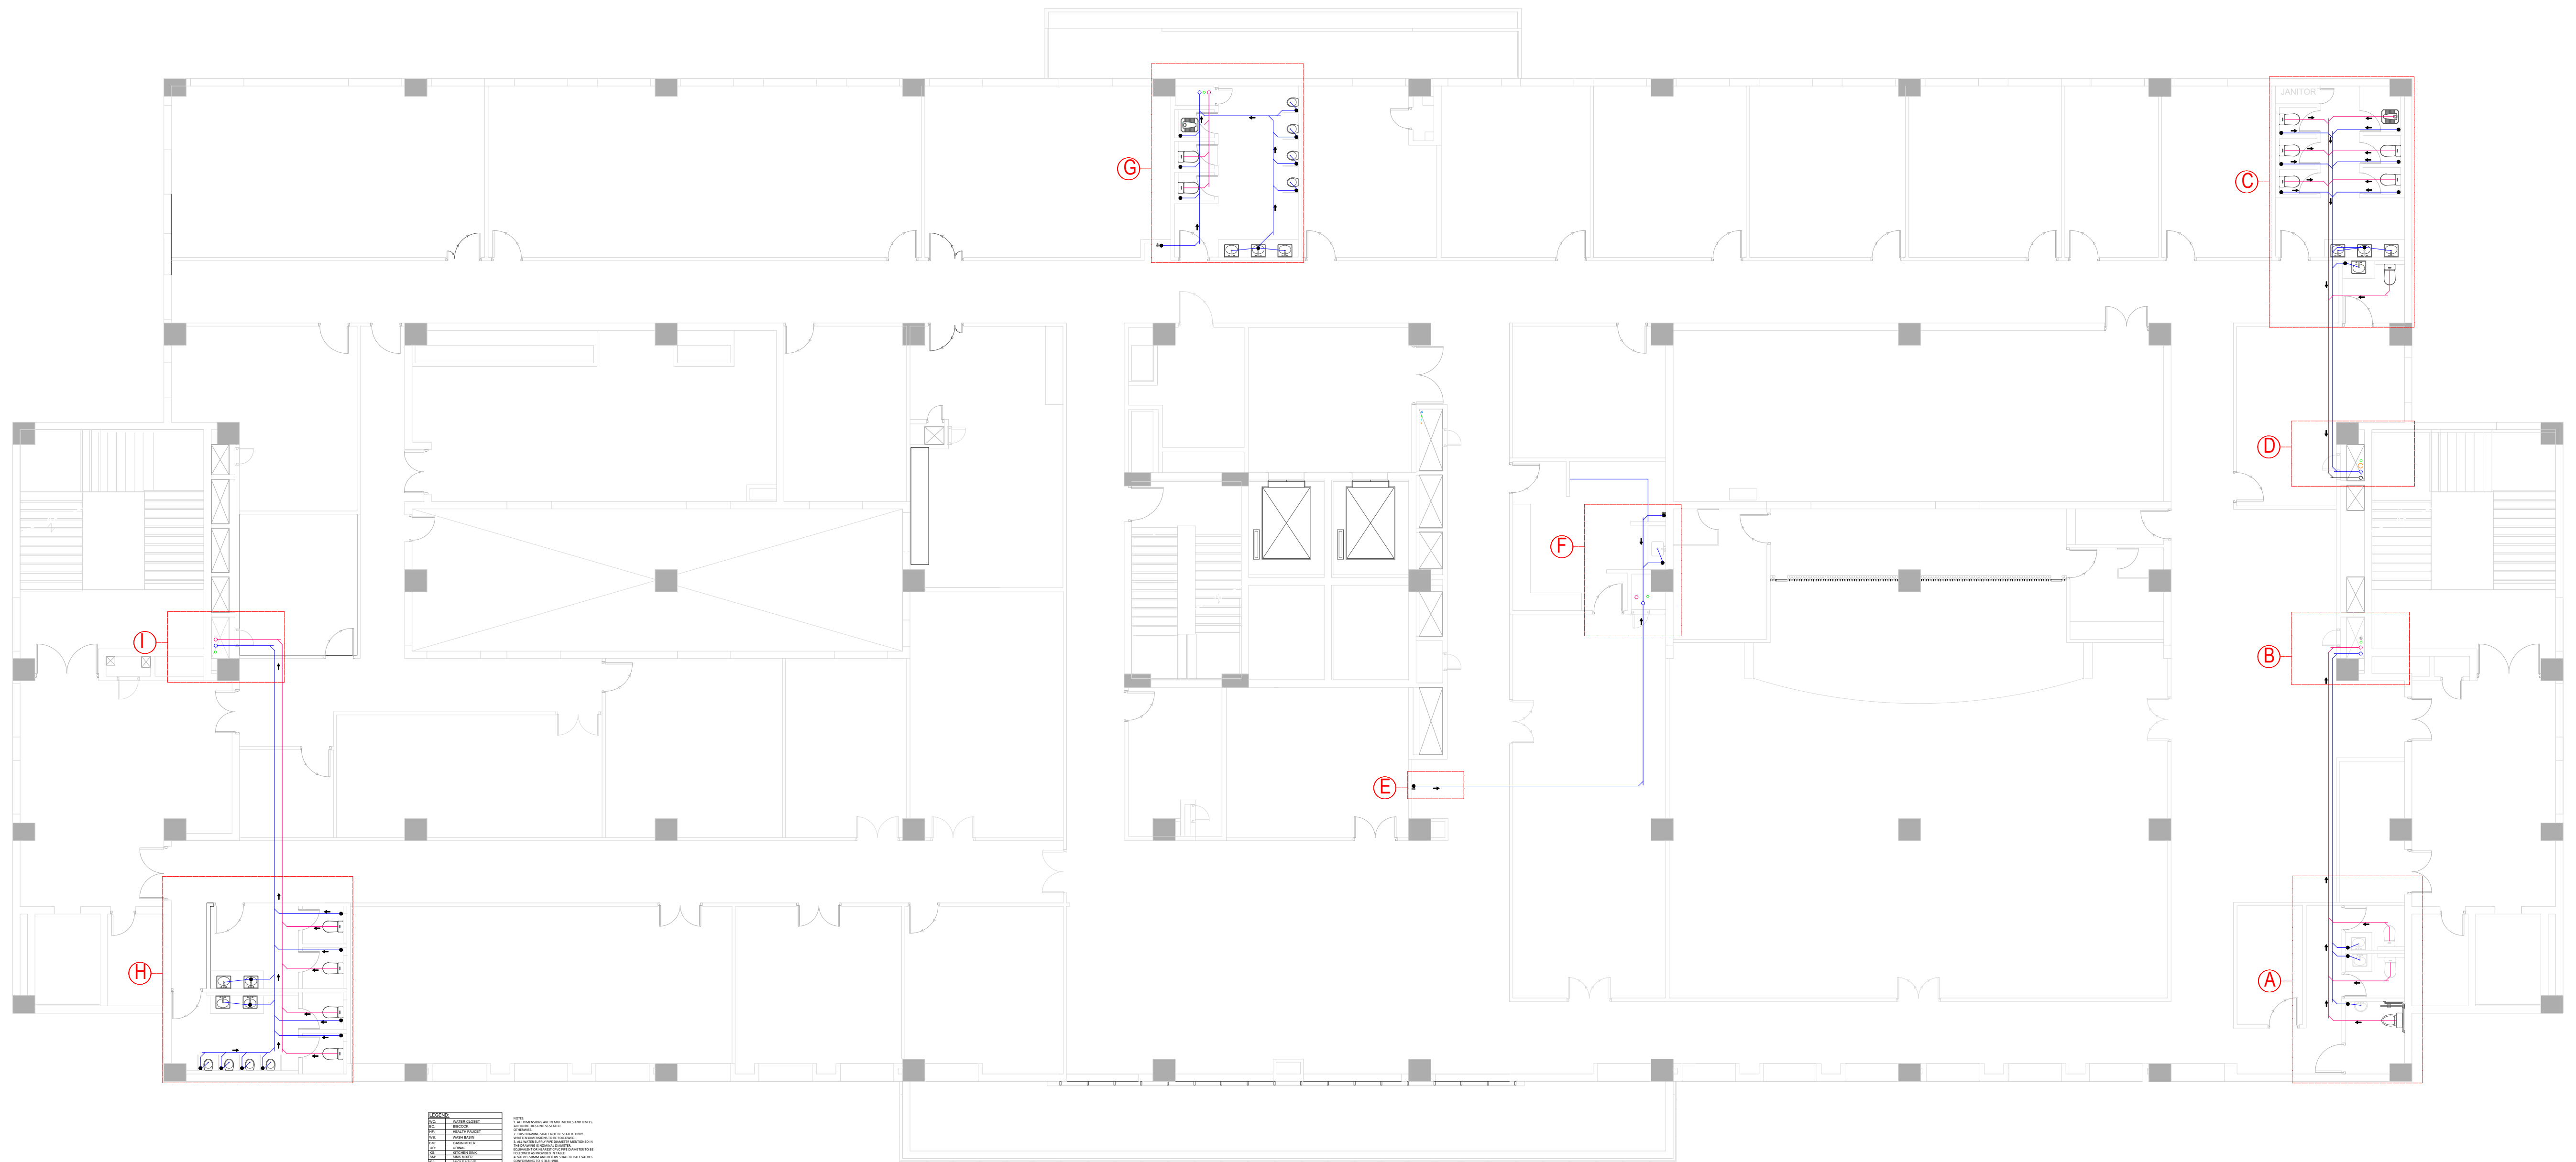

ITEM NO.	DESCRIPTION	QTY	UNIT
1	1.000	1	1
2	2.000	2	2
3	3.000	3	3
100	100.000	100	100

5TH FLOOR SANITARY LAYOUT

PROJECT NAME PROPOSED OF NURSING COLLEGE AT 5TH AND 6TH FLOOR OF DIPHU CANCER CENTRE, DIPHU
CLIENT ASSAM CANCER CARE FOUNDATION

DRAWING TITLE FIFTH FLOOR PLAN PROPOSED NURSING COLLEGE
AREA

DWG NO.	ASSM/DCC/DIPHU/FIFTH FLOOR/SANITARY LAYOUT A101
DATE	
SCALE	
DWN BY	LVE

REVISION DATA

NOTE :
1. Do not scale the drawing, follow written dimension only.
2. All dimensions in mm. and levels in meters.
3. This dwg should be read along with relevant structural dwg.
4. Toilet, Pantry, Kitchen level shall be 12mm below the FFL.

CONSULTANT LUIT VALLEY ENGINEERING PVT. LTD. PALTAN BAZAR, GUWAHATI 781008(INDIA)
