


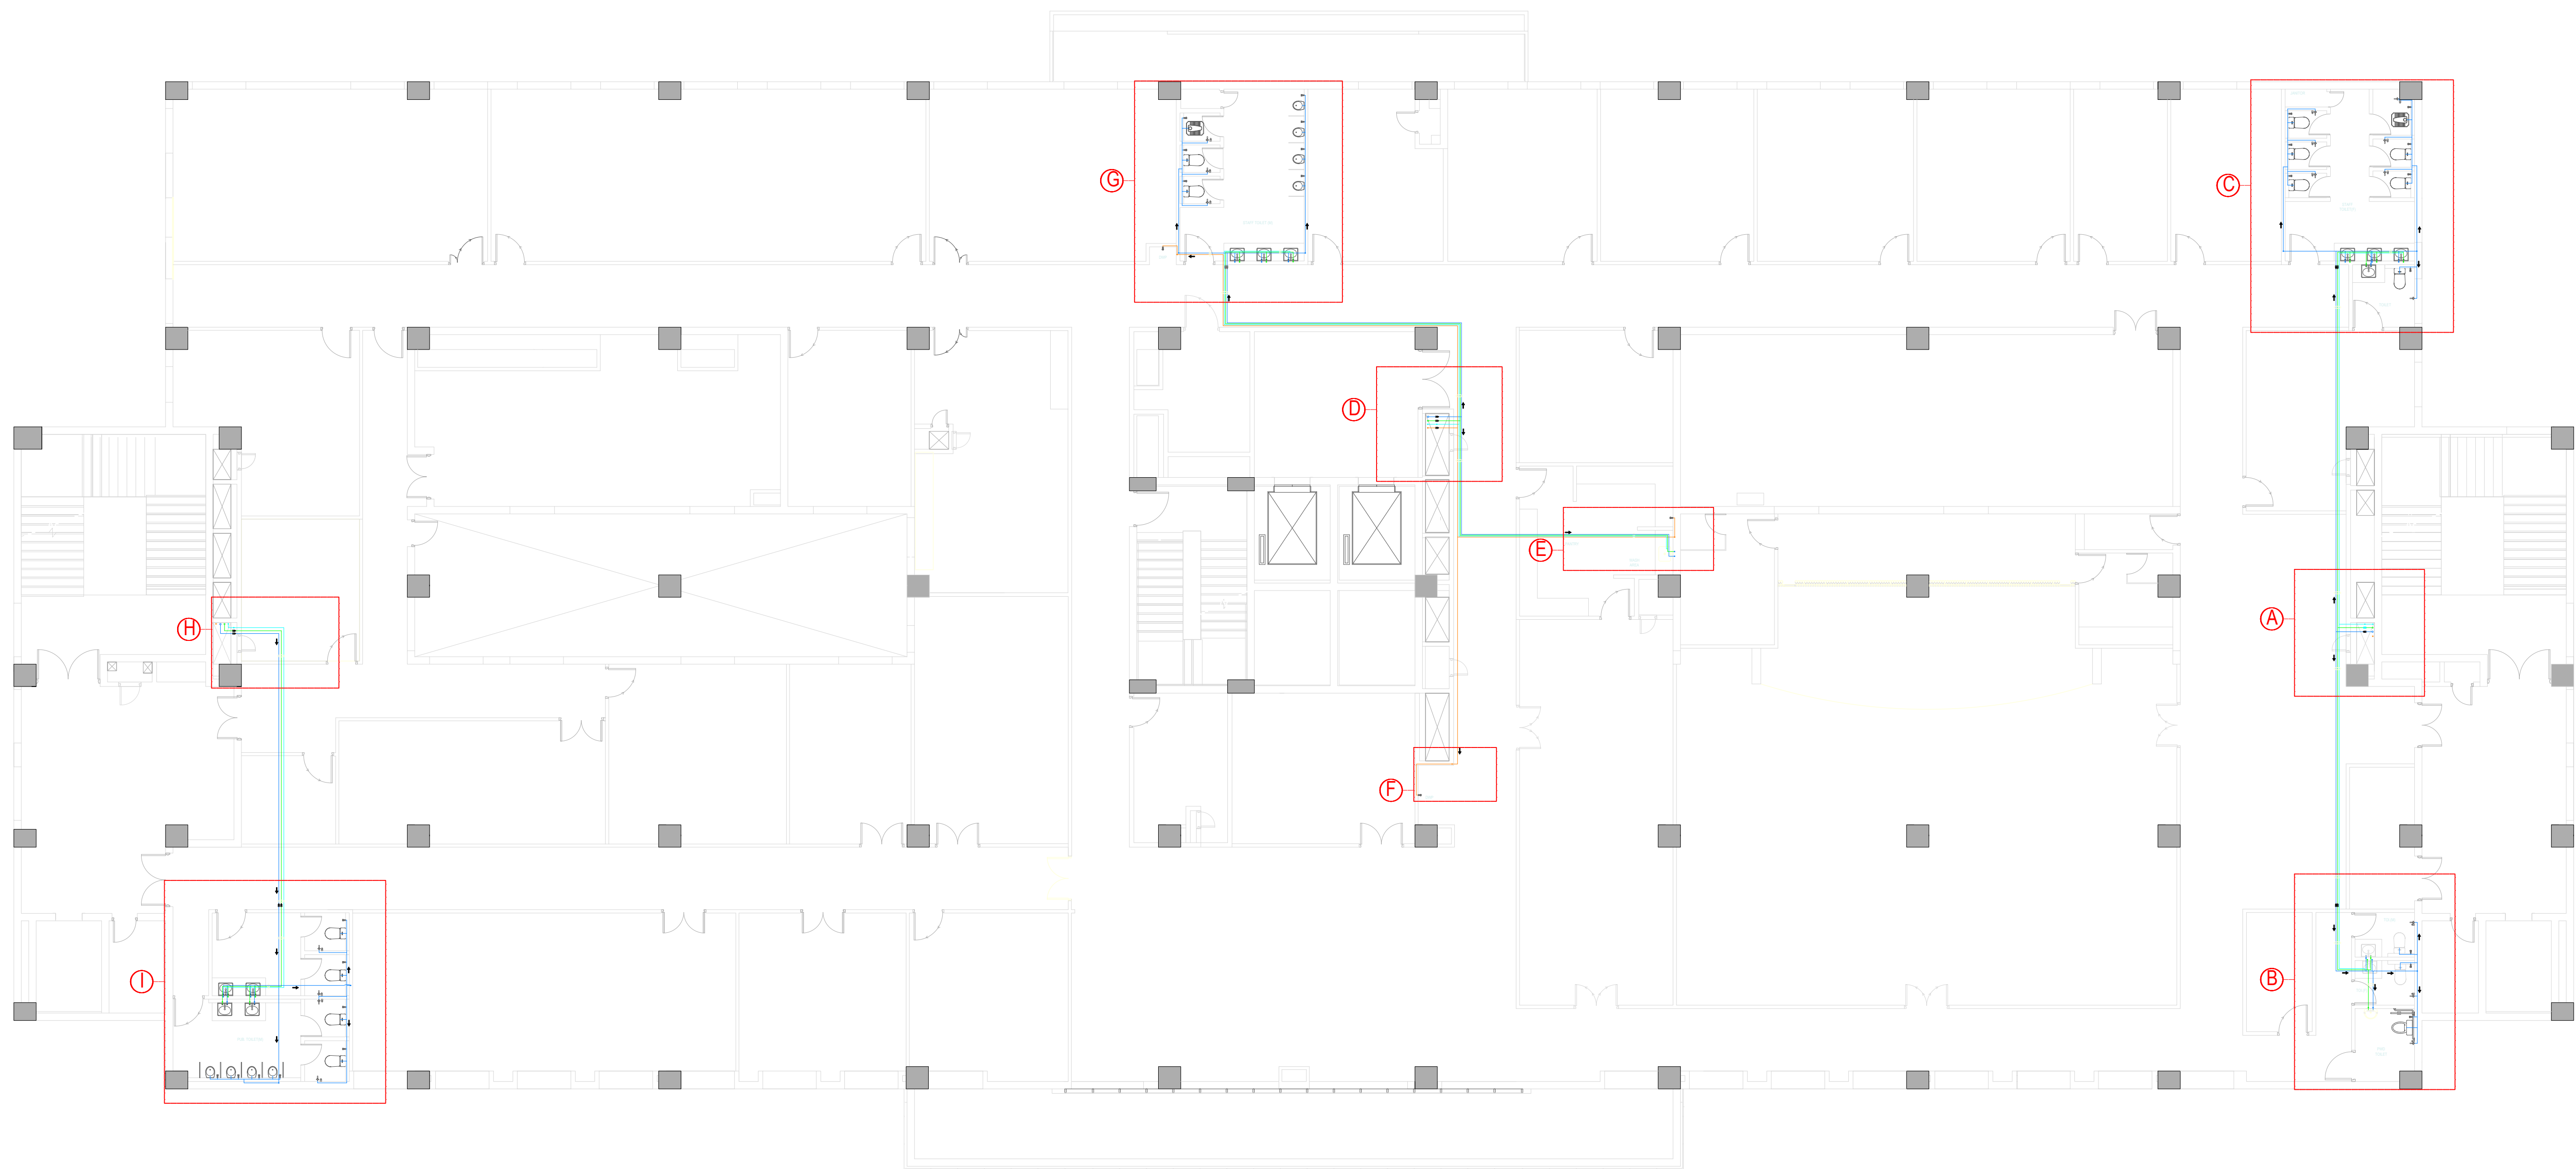

5TH FLOOR WATER SUPPLY LAYOUT

PROJECT NAME
PROPOSED OF NURSING COLLEGE AT 5TH AND 6TH FLOOR OF DIPHU CANCER
CENTRE, DIPHU

CLIENT
ASSAM CANCER CARE FOUNDATION

DRAWING TITLE
FIFTH FLOOR PLAN
PROPOSED NURSING COLLEGE

AREA

DWG NO. ASSM/DCC/DIPHU/FIFTH
FLOOR/WATER SUPPLY LAYOUTA101

DATE

SCALE

DWN BY LVE

REVISION DATA

NOTE :

1. Do not scale the drawing, follow written dimension only.
2. All dimensions in mm. and levels in meters.
3. This dwg should be read along with relevant structural dwg.
4. Toilet, Pantry, Kitchen level shall be 12mm below the FFL.

CONSULTANT

LUIT VALLEY ENGINEERING PVT. LTD.
PALTAN BAZAR, GUWAHATI 781008(INDIA)